


## 0 5 10 m LIIIIIIII scale

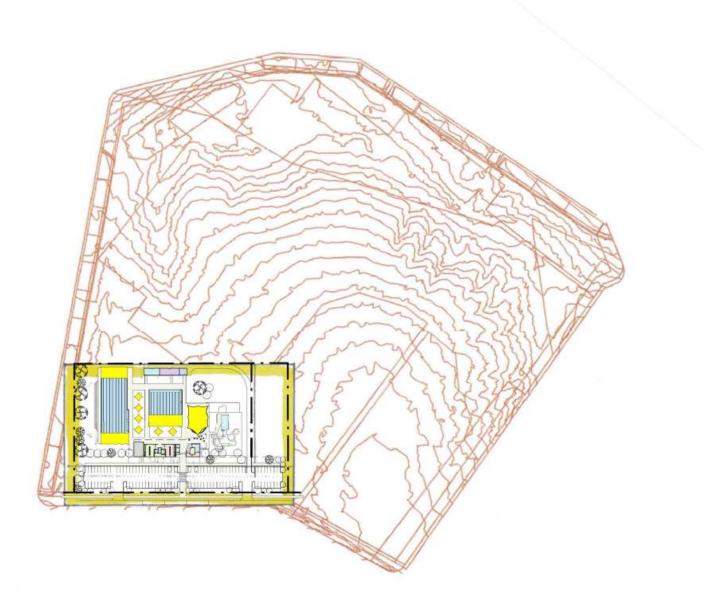



FACILITY DESIGN GROUP	PROJECT C BOYNE TANUM AQUATIC RECREATION CENTRE	CLIENT	drawing title SITE PLAN 1	
DESIGN GROUP DONOT SCALE OF DRAWINGS, WORK TO REVIEW DIMINISONE ONLY.			DRAWING No. A050	REVISION
Architecture & Construction NOMINATED ARCHITECT: STEPHEN JOHANSSON - NSW REG No. 7148	THE DRAWING IS COPYING IT A 5 THE PROPERTY OF FACILITY DESIGN GROUP PTY JTD		SCALE 1:2000 DATE 6/5/20 JOB No. Project	a
			Number	